




peterson ARCHITECTURE
298 south 10th street
suite 500
noblesville in 46060
p 317.770.9714
f 317.770.9718
studio@petersonarchitecture.com

Mill Creek Design, Inc
**MECHANICAL, ELECTRICAL, PLUMBING,
INDUSTRIAL, & SOLAR DESIGN**

359A W. 600 S. PO BOX 319 CLAYTON, IN 46118
MCD@MILLCREEK-DESIGN.COM (317) 281-6342

6312 RAILROAD STREET
MC CORDSVILLE, INDIANA

**NEW CONSTRUCTION
GREEN TOUCH
MACDOUGALL PIERCE CONSTRUCTION**

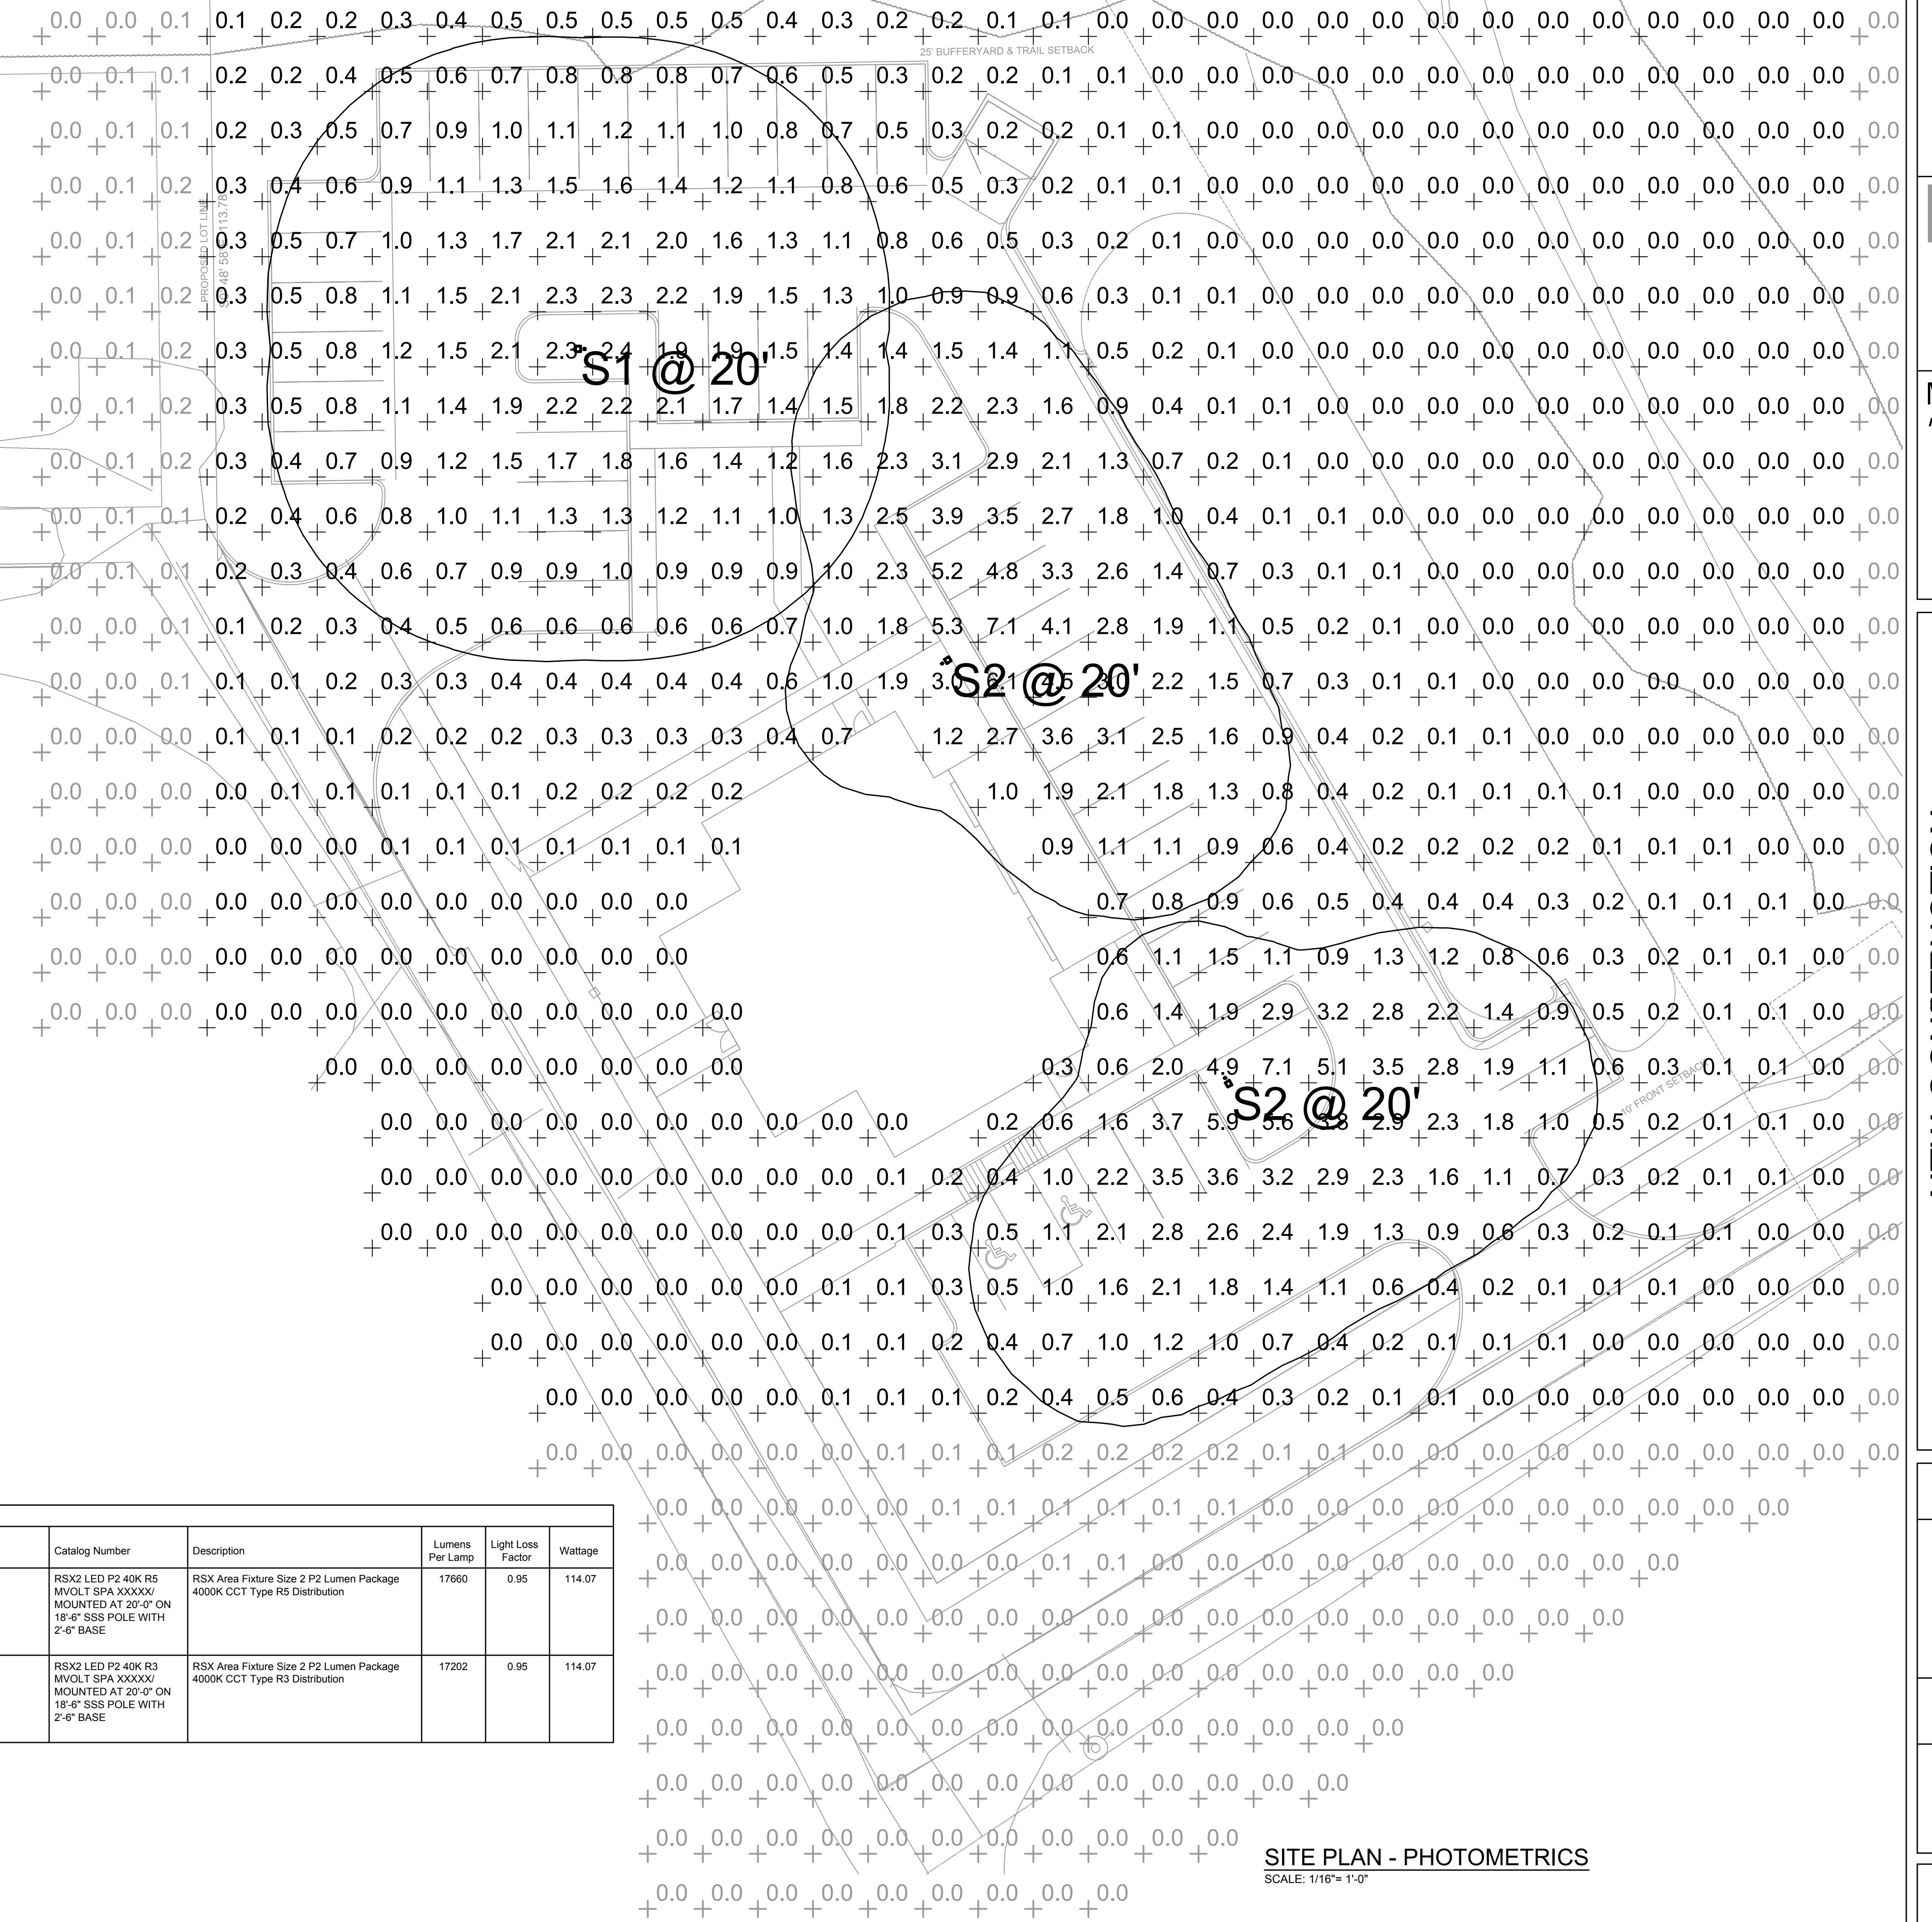

100% CONSTRUCTION DRAWINGS
01/20/2024

REVISIONS:
▲ REVISION DATE
△ REVISION DATE
△ REVISION DATE
△ REVISION DATE
△ REVISION DATE

DRAWN BY: JMS
CHECKED BY: PUH
PROJECT NUMBER: 23-463

SITE PLAN - PHOTOMETRICS

E204

THESE DRAWINGS ARE GIVEN IN CONFIDENCE AND SHALL BE USED ONLY IN PURSUANT TO THE AGREEMENT WITH PETERSON ARCHITECTURE, P.C.
NO OTHER USE OR DUPLICATION MAY BE MADE WITHOUT THE PRIOR WRITTEN CONSENT OF PETERSON ARCHITECTURE, P.C.
ALL OTHER COPYRIGHT AND COMMON LAW RIGHTS ARE HEREBY SPECIFICALLY RESERVED.